
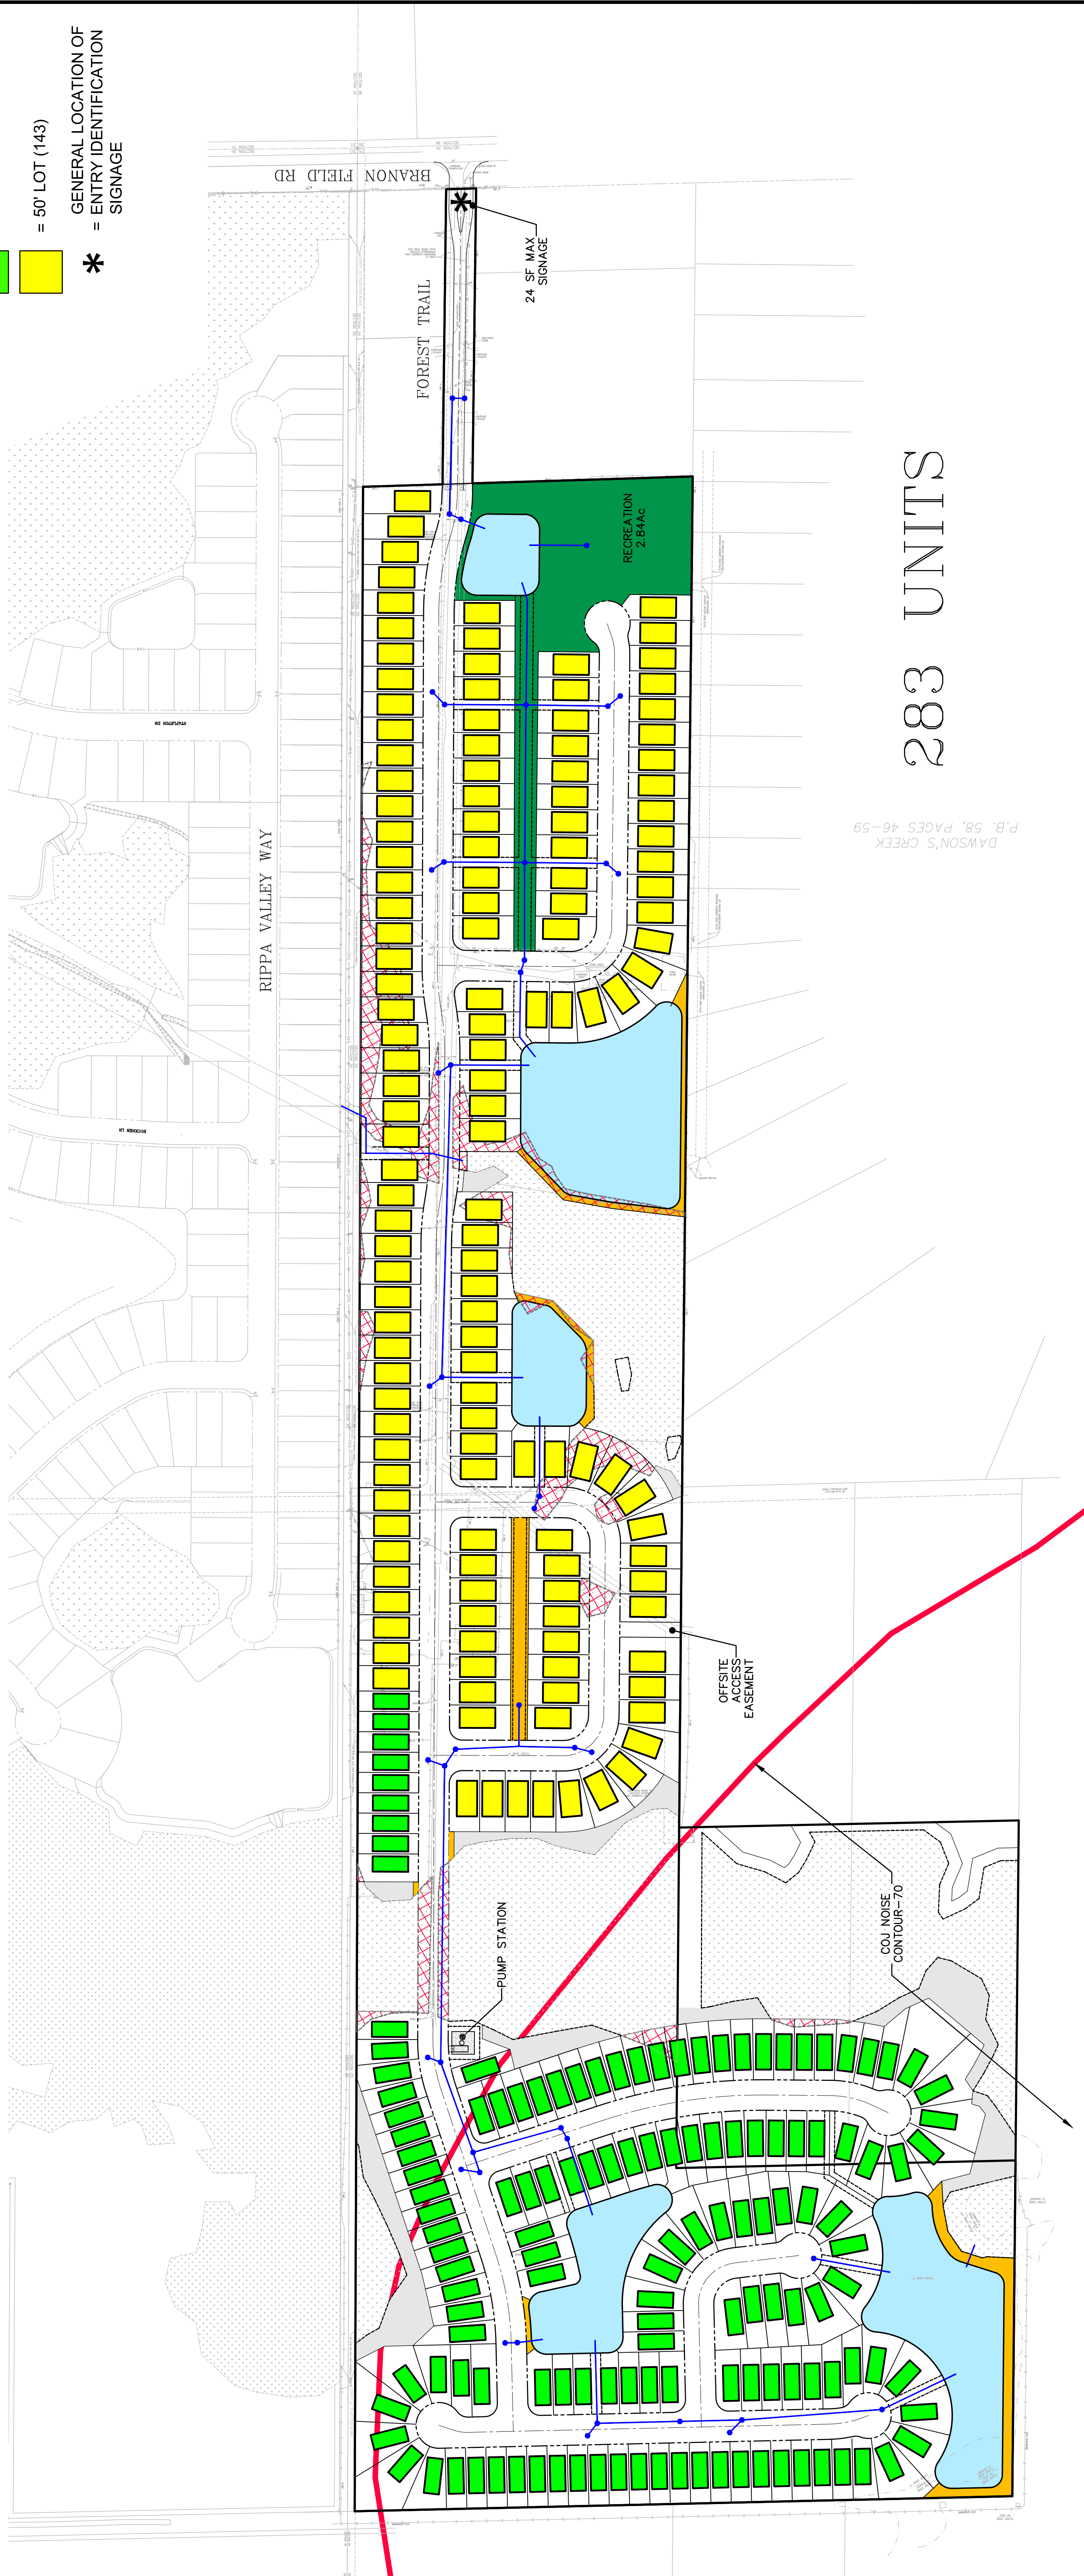


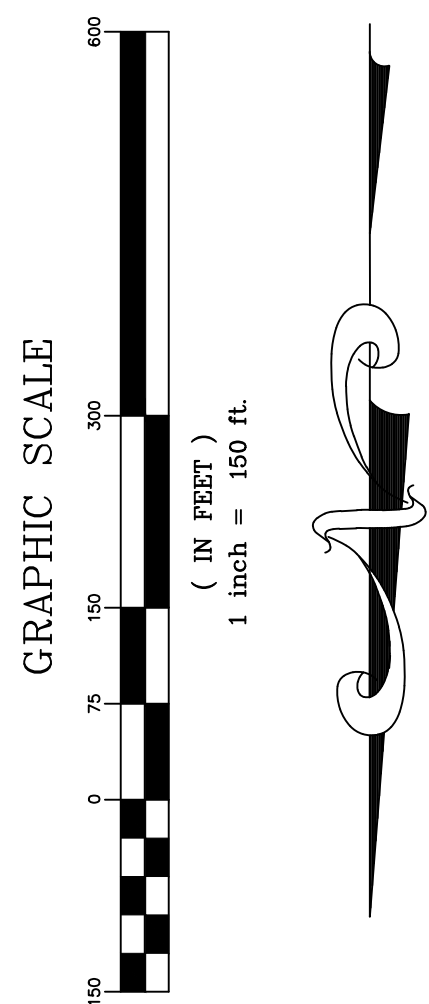

UNIT 328

2. \POTENTIAL PROJECTS\ DREAM FINDERS HOMES\ 0024-12 BRANAN FIELD ROAD\ CONCEPTUAL\ BFR CON-12_W-LIDAR.DWG10/17/2024 8:35 AMSteve Murrin

DESIGNED BY: MR


DRAWN BY: MR

CHECKED BY: VID/DMT

SCALF. 1" = 150'

DATE: 0-4-1-12 305

DATE.	October 17, 2001
DEPT. NO.	000140

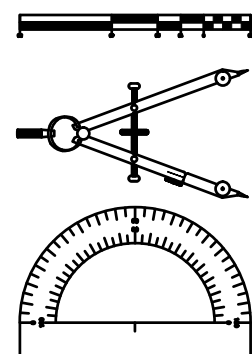

Dunn & Associates, Inc.

CIVIL ENGINEERS / LAND PLANNERS

8647 Baypine Road, Suite 200
Jacksonville, Florida 32256

Phone: (904)363-8916 Fax: (904)363-8917

www.dunneng.com

BRANAN FIELD RD

FOR:

DREAM FINDERS HOMES

DUVAL COUNTY, FLORIDA

PRELIMINARY SITE PLAN

Sheet No. 1 of 1

CON-12

DWG. NO.